






PROJECT CONSTRUCTION OF ISLAND WASTE MANAGMENT CENTER AT LAAMU.KUNAHANDHOO ISLAND

PREPARED BY
United Nations Development Programme

CONTENT

KUNAHANDHOO DRAWINGS

SL.NO	DRAWING NAME	DRAWING NUMBER
1	SITE PLAN	00088179/2017/IWMC/KUN/001
2	FLOOR PLAN	00088179/2017/IWMC/KUN/002
3	FOUNDATION PLAN	00088179/2017/IWMC/KUN/003
4	ROOF FRAME PLAN	00088179/2017/IWMC/KUN/004
5	ROOF PLAN	00088179/2017/IWMC/KUN/005
6	PLUMBING LAYOUT	00088179/2017/IWMC/KUN/006
7	ELECTRICAL LAYOUT	00088179/2017/IWMC/KUN/007

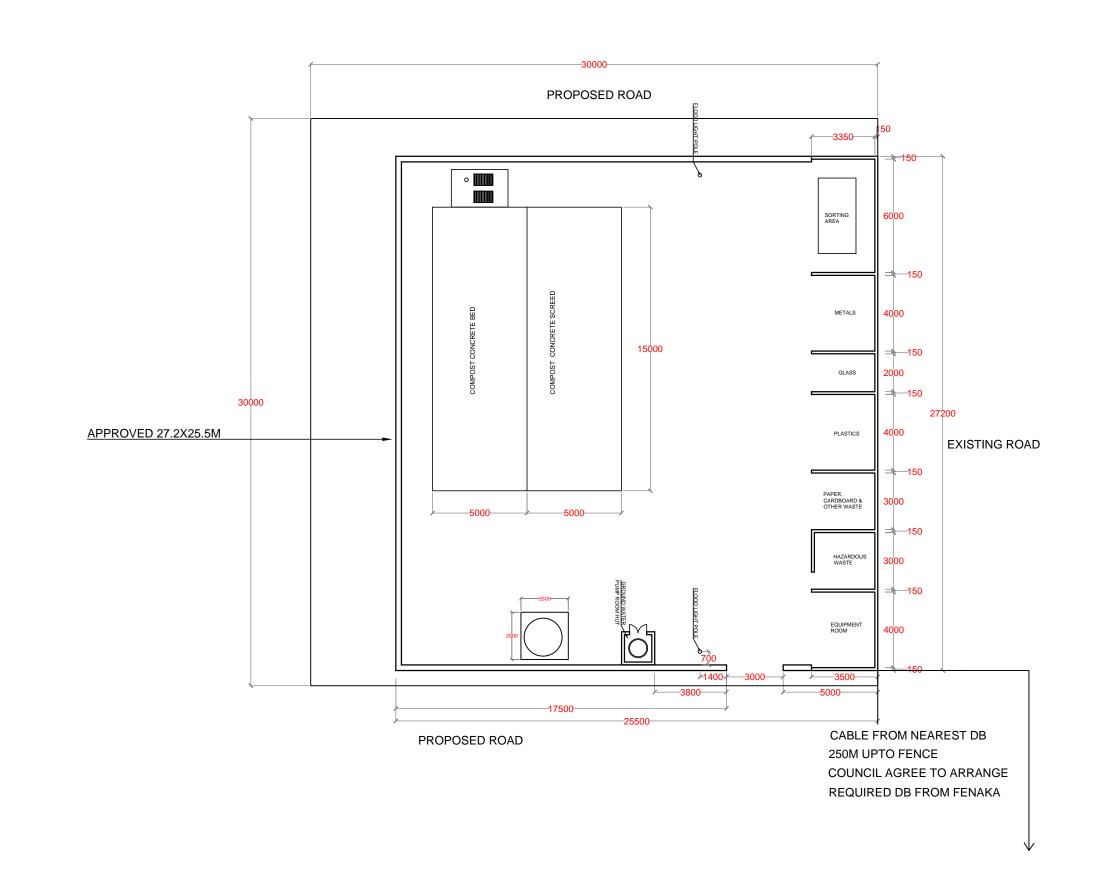



G.SARAVANAN CONSULTANT-CIVIL ENGINEER

CHECKED BY:

FATHIMATH SHAFA-ATH ENGINEER- MEE

APPROVED BY:

 
AISHATH AZFA

PROJECT MANAGER-LECRED-UNDP

IMPLEMENTING AGENCY:



United Nations Development Programme





Ministry of Energy **Environment and**

PROGRAMME:



Low Emission Climate Resilient Develop

PROJECT NAME:

CONSTRUCTION & UPGRADE OF IWMC FOR 10 ISLANDS IN LAAMU ATOLL

ISLAND NAME:

LAAMU. KUNAHANDHOO

LOCATION:

ISLAND WASTE MANAGEMENT CENTER


DRAWING NAME:


SITE PLAN

DRAWING NO:

DATE :	APRIL 2017	
SCALE :	1:200	
PROJECT NO :	00088179	



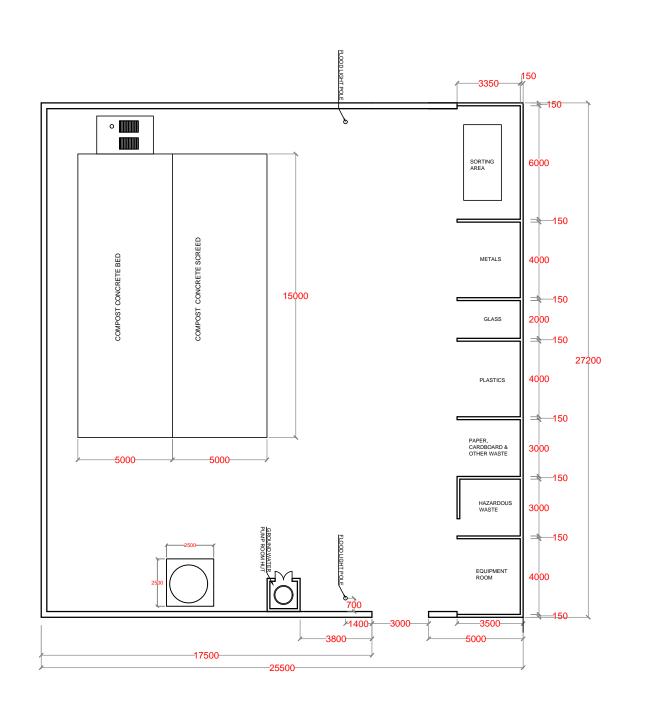

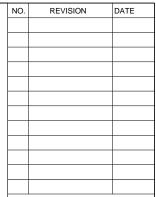

G.SARAVANAN CONSULTANT-CIVIL ENGINEER

CHECKED BY:

FATHIMATH SHAFA-ATH ENGINEER- MEE

APPROVED BY:

 
AISHATH AZFA

PROJECT MANAGER-LECRED-UNDP

IMPLEMENTING AGENCY:



United Nations Development Programme





Ministry of Environment and Energy

PROGRAMME:



Low Emission Climate Resilient Developm

PROJECT NAME:

CONSTRUCTION & UPGRADE OF IWMC FOR 10 ISLANDS IN LAAMU ATOLL

ISLAND NAME:

LAAMU. KUNAHANDHOO

LOCATION:


ISLAND WASTE MANAGEMENT CENTER

DRAWING NAME:

FLOOR PLAN

DRAWING NO:

DATE :	APRIL 2017
SCALE :	1:200
PROJECT NO :	00088179

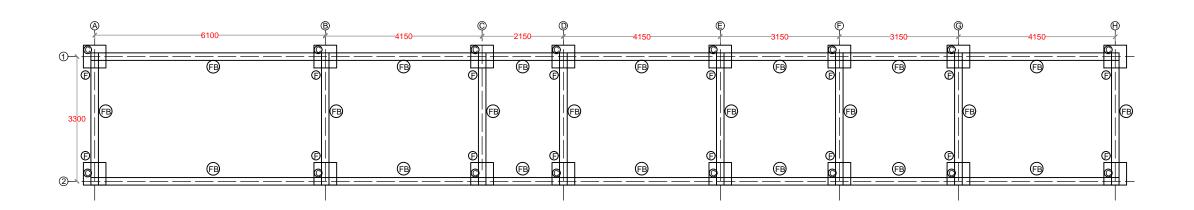

FOUNDATION PLAN

PREPARED BY:

REVISION

DATE

G.SARAVANAN CONSULTANT-CIVIL ENGINEER

CHECKED BY:

NO.

FATHIMATH SHAFA-ATH ENGINEER- MEE

APPROVED BY:

AISHATH AZFA

 
PROJECT MANAGER-LECRED-UNDP

IMPLEMENTING AGENCY:



United Nations Development Programme





Low Emission
Climate Resilient
Development

Low Emission Climate Resilient Developm
PROJECT NAME:

CONSTRUCTION &
UPGRADE OF IWMC FOR 10
ISLANDS IN LAAMU ATOLL

ISLAND NAME:

LAAMU. KUNAHANDHOO

LOCATION:


ISLAND WASTE MANAGEMENT CENTER

DRAWING NAME:


FOUNDATION PLAN


DRAWING NO:

DATE :	APRIL 2017	
SCALE :	1:100	
PROJECT NO :	00088179	

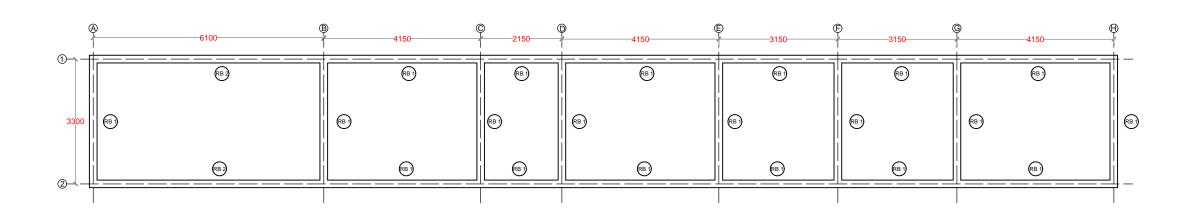

ROOF BEAM PLAN

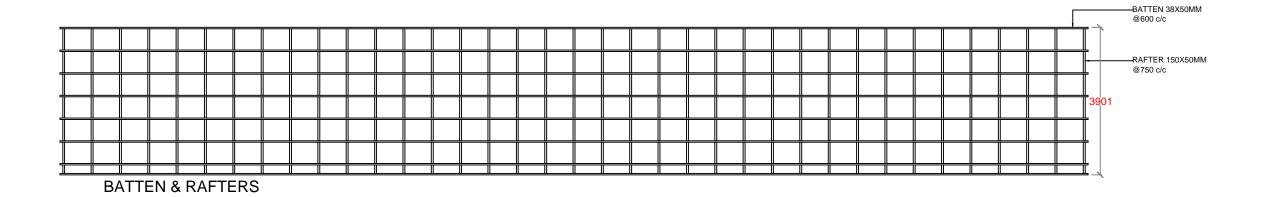

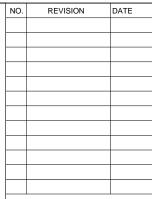

PREPARED BY:

G.SARAVANAN CONSULTANT-CIVIL ENGINEER

CHECKED BY:

FATHIMATH SHAFA-ATH ENGINEER- MEE

APPROVED BY:

AISHATH AZFA PROJECT MANAGER-LECRED-UNDP



United Nations Development Programme



Ministry of Environmen Energy Environment and

PROGRAMME:



Climate Resilient LECRED

A Programma Funded in the Covernment of Covernment of Covernment and Entire or the Vision partnership with the Covernment of Middlines,

Low Emission Climate Resilient Developm PROJECT NAME:

CONSTRUCTION & UPGRADE OF IWMC FOR 10 ISLANDS IN LAAMU ATOLL

ISLAND NAME:

LAAMU. KUNAHANDHOO

LOCATION:


ISLAND WASTE MANAGEMENT CENTER


DRAWING NAME:

ROOF FRAME PLAN

DRAWING NO:

DATE :	APRIL 2017
SCALE :	1:100
PROJECT NO :	00088179

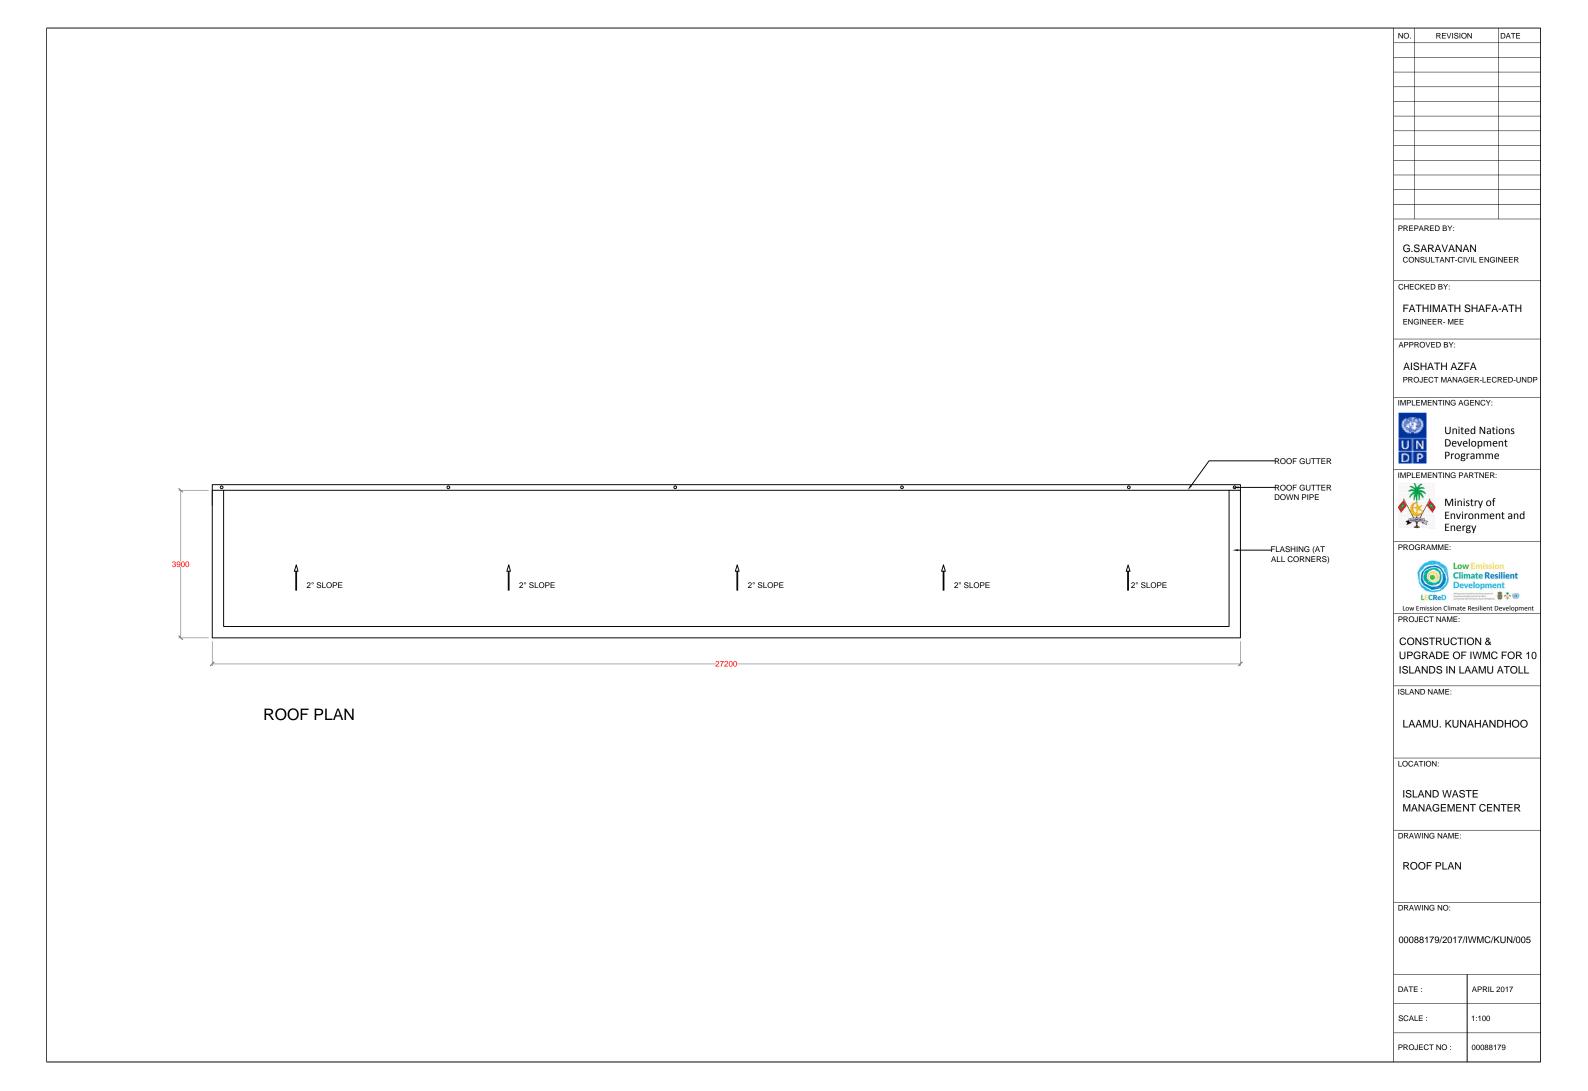

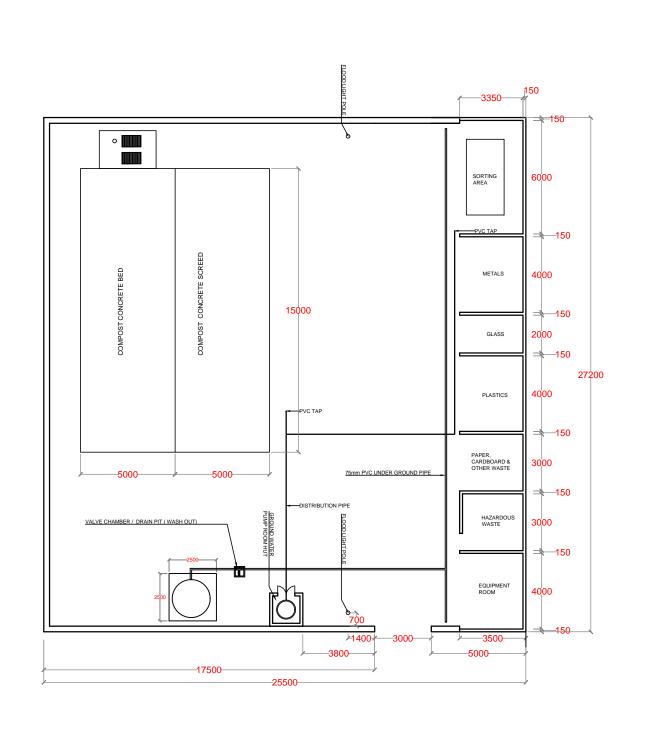



G.SARAVANAN CONSULTANT-CIVIL ENGINEER

CHECKED BY:

FATHIMATH SHAFA-ATH ENGINEER- MEE

APPROVED BY:

AISHATH AZFA

PROJECT MANAGER-LECRED-UNDP

IMPLEMENTING AGENCY:



United Nations Development Programme

IMPLEMENTING PARTNER:



Ministry of Environment and Energy

PROGRAMME:



LECRED A Programme funded to the Operaneurs of Section 2 A Programme for Section 2 A Programme f Low Emission Climate Resilient Developm

PROJECT NAME:

CONSTRUCTION & UPGRADE OF IWMC FOR 10 ISLANDS IN LAAMU ATOLL

ISLAND NAME:

LAAMU. KUNAHANDHOO

LOCATION:


ISLAND WASTE MANAGEMENT CENTER

DRAWING NAME:

PLUMBING LAYOUT

DRAWING NO:

DATE :	APRIL 2017
SCALE :	1:200
PROJECT NO :	00088179

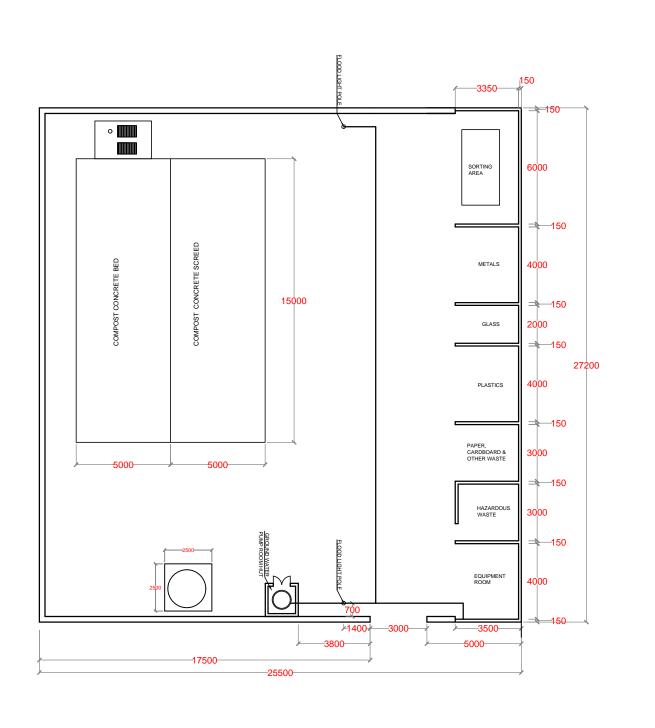

NO.	REVISION	DATE

G.SARAVANAN CONSULTANT-CIVIL ENGINEER

CHECKED BY:

FATHIMATH SHAFA-ATH ENGINEER- MEE

APPROVED BY:

AISHATH AZFA

PROJECT MANAGER-LECRED-UNDP

IMPLEMENTING AGENCY:



United Nations Development Programme





Ministry of Environmen Energy **Environment and**

PROGRAMME:



Low Emission Climate Resilient Developm

PROJECT NAME:

CONSTRUCTION & UPGRADE OF IWMC FOR 10 ISLANDS IN LAAMU ATOLL

ISLAND NAME:

LAAMU. KUNAHANDHOO

LOCATION:

ISLAND WASTE MANAGEMENT CENTER

DRAWING NAME:

ELECTRICAL LAYOUT


DRAWING NO:


DATE :	APRIL 2017
SCALE :	1:200
PROJECT NO :	00088179

CONTENT

STANDARD DRAWINGS (APPLICABLE FOR ALL ISLANDS)

SL.NO	DRAWING NAME	DRAWING NUMBER
1	STRUCTURAL DETAILS - 1	00088179/2017/IWMC/SD/001
2	STRUCTURAL DETAILS - 2	00088179/2017/IWMC/SD/002
3	CONCRETE BED / SCREED REINFORCEMENT DETAIL	00088179/2017/IWMC/SD/003
4	CONCRETE BED / SCREED PLAN	00088179/2017/IWMC/SD/003A
5	SORTING TABLE	00088179/2017/IWMC/SD/004
6	LEACHETE TANK	00088179/2017/IWMC/SD/005
7	ELEVATION & SECTION	00088179/2017/IWMC/SD/006
8	PUMP ROOM HUT DETAILS	00088179/2017/IWMC/SD/007
9	SLIDING DOOR DETAILS	00088179/2017/IWMC/SD/008
10	ELECTRICAL LAYOUT	00088179/2017/IWMC/SD/009
11	GROUND WATER WELL & RAINWATER TANK DETAILS	00088179/2017/IWMC/SD/010
12	FLOOD LIGHT DETAILS	00088179/2017/IWMC/SD/011
13	STREET DB STAND & CABLE TRENCH DETAILS	00088179/2017/IWMC/SD/012

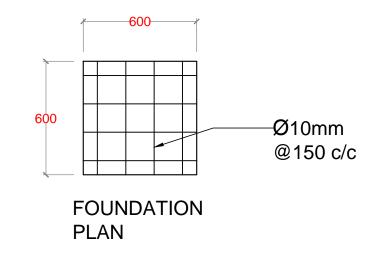

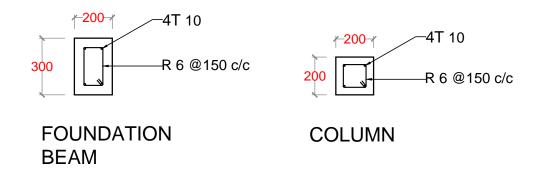


ROOF BEAM DETAILS


COLUMN COLUMN R 6 @ 150 c/c 4T 10 FOUNDATION BEAM FOOTING 50MM THICK LEAN CONCRETE

FOUNDATION


SECTION

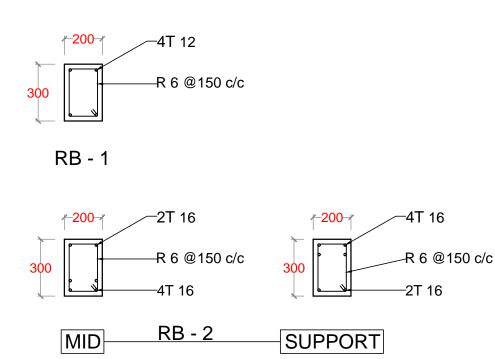




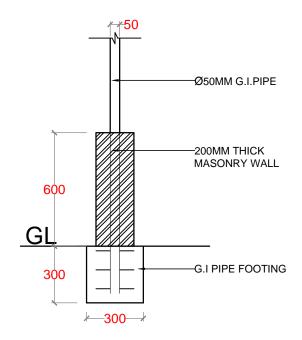


FENCING FOUNDATION DETAILS SCALE - 1:20

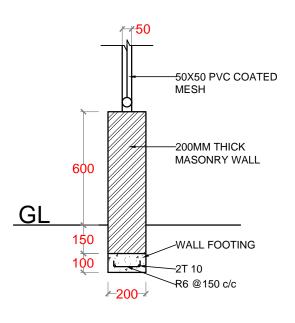

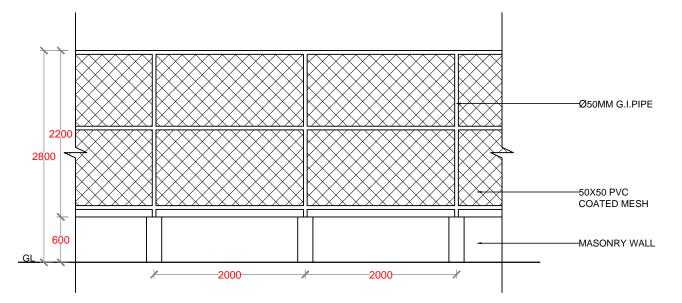

PERIMETER FENCE

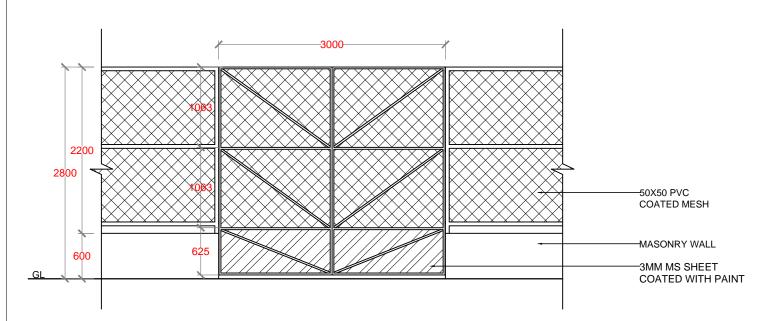

MAIN GATE

FENCING DETAILS SCALE - 1:50

NO.	REVISION	DATE
DDE	DADED BV:	

PREPARED BY:

G.SARAVANAN CONSULTANT-CIVIL ENGINEER

CHECKED BY:

FATHIMATH SHAFA-ATH ENGINEER- MEE

 
APPROVED BY:

AISHATH AZFA
PROJECT MANAGER-LECRED-UNDP

IMPLEMENTING AGENCY:



United Nations Development Programme





Ministry of
Environment and
Energy

PROGRAMME:



Climate Resilient Development

ReD State of the National Action of t

Low Emission Climate Resilient Develop

PROJECT NAME:

CONSTRUCTION & UPGRADE OF IWMC FOR 10 ISLANDS IN LAAMU ATOLL

ISLAND NAME:

LAAMU.

LOCATION:

ISLAND WASTE MANAGEMENT CENTER

DRAWING NAME:

STRUCTURAL DETAILS - 2


DRAWING NO:

00088179/2017/IWMC/SD/002


DATE: APRIL 2017


SCALE: 1:50

PROJECT NO: 00088179

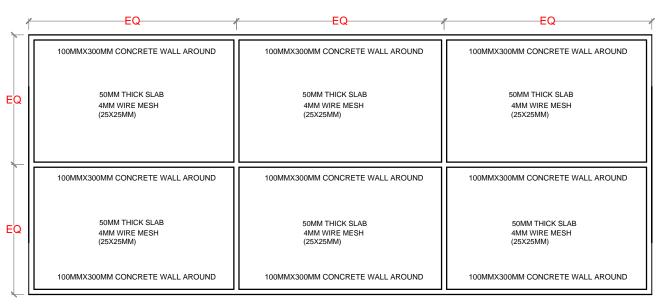

COMPOST CONCRETE SCREED - PLAN

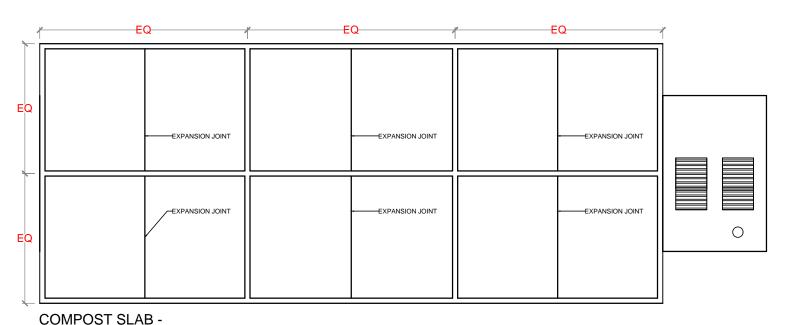

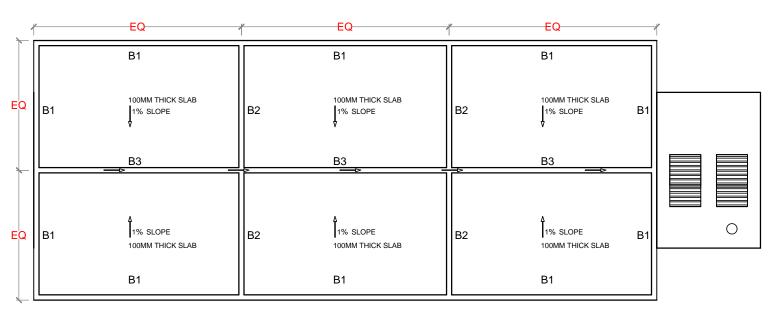

COMPOST SLAB - PLAN

JOINTS AND SPACING

NO.	REVISION	DATE
DD.	DADED DV	

PREPARED BY:

G.SARAVANAN CONSULTANT-CIVIL ENGINEER

CHECKED BY:

FATHIMATH SHAFA-ATH ENGINEER- MEE

APPROVED BY:

AISHATH AZFA
PROJECT MANAGER-LECRED-UNDP

IMPLEMENTING AGENCY:



United Nations Development Programme



Ministry of Environment and Energy

PROGRAMME:



Argument value for a foresteror of the control of t

PROJECT NAME:

CONSTRUCTION &
UPGRADE OF IWMC FOR 10
ISLANDS IN LAAMU ATOLL

ISLAND NAME:

LAAMU.

LOCATION:

ISLAND WASTE MANAGEMENT CENTER

DRAWING NAME:

CONCRETE BED / SCREED REINFORCEMENT DETAIL


DRAWING NO:

00088179/2017/IWMC/SD/003A

DATE: APRIL 2017

SCALE: 1:20


PROJECT NO: 00088179

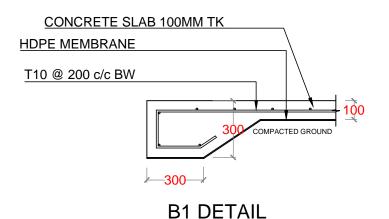


HDPE MEMBRANE


COMPACTED GROUND

4MM MESH 25X25MM GRID

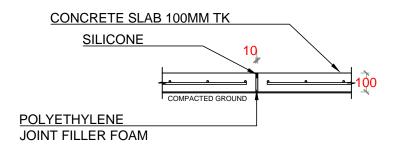

SLAB EXPANSION JOINT DETAIL

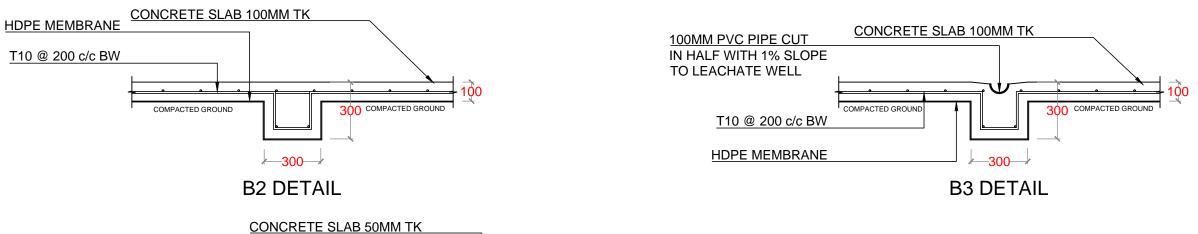

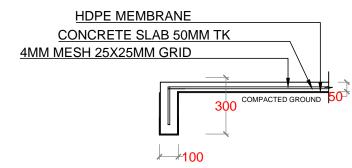

COMPOST CONCRETE SCREED & WALL

COMPACTED GROUND

NO.	REVISION	DATE
PRE	PARED BY:	

G.SARAVANAN CONSULTANT-CIVIL ENGINEER

CHECKED BY:

FATHIMATH SHAFA-ATH ENGINEER- MEE

APPROVED BY:

AISHATH AZFA

PROJECT MANAGER-LECRED-UNDP

IMPLEMENTING AGENCY:



United Nations Development Programme



Ministry of **Environment and** Energy

PROGRAMME:



Low Emission Climate Resilient Develo

PROJECT NAME:

CONSTRUCTION & UPGRADE OF IWMC FOR 10 ISLANDS IN LAAMU ATOLL

ISLAND NAME:

LAAMU.

LOCATION:


ISLAND WASTE MANAGEMENT CENTER


DRAWING NAME:


CONCRETE BED / SCREED REINFORCEMENT DETAIL


DRAWING NO:


DATE :	APRIL 2017
SCALE :	1:20
PROJECT NO :	00088179

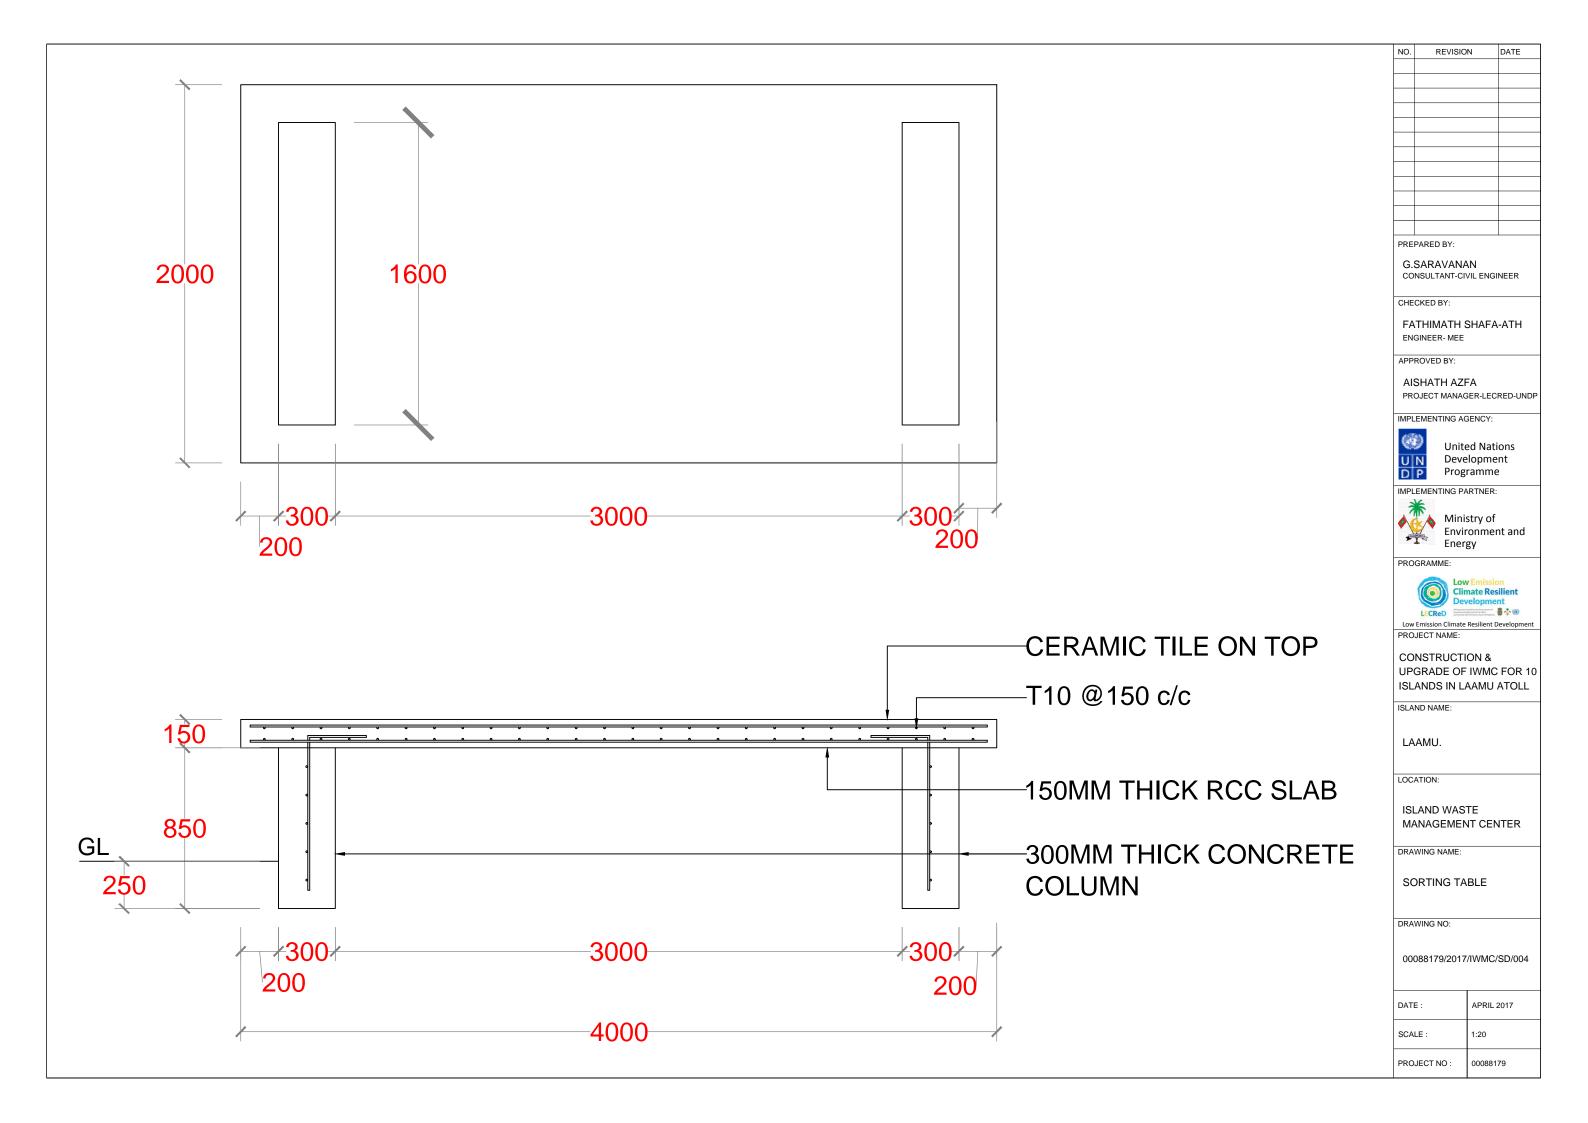


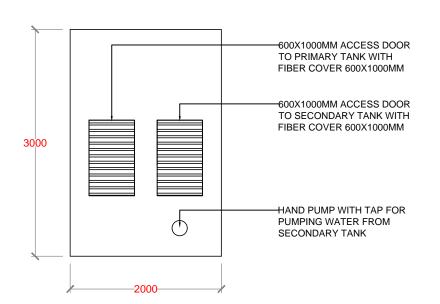


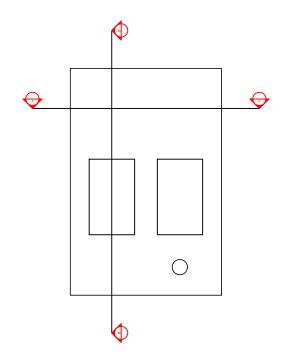

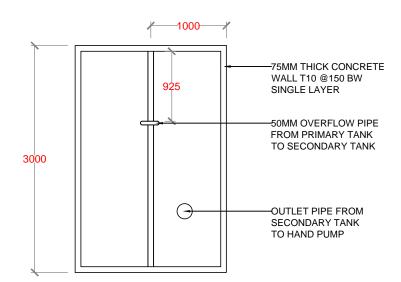

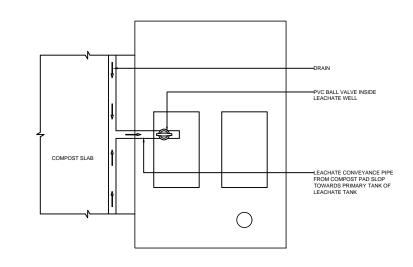

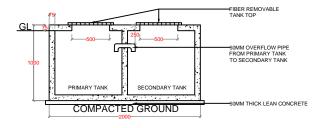

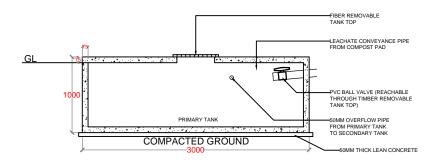

NO.	REVISION	DATE	

G.SARAVANAN CONSULTANT-CIVIL ENGINEER

CHECKED BY:

FATHIMATH SHAFA-ATH ENGINEER- MEE

APPROVED BY:

AISHATH AZFA

PROJECT MANAGER-LECRED-UNDP

IMPLEMENTING AGENCY:



United Nations Development Programme

IMPLEMENTING PARTNER:



Ministry of
Environment and
Energy

PROGRAMME:



Climate Resilient Development

LECRED

Climate Resilient Development

Abyene Model in Grammari Model in the Community of the

Low Emission Climate Resilient Developmen

PROJECT NAME:

CONSTRUCTION &
UPGRADE OF IWMC FOR 10
ISLANDS IN LAAMU ATOLL

ISLAND NAME:

LAAMU.

LOCATION:


ISLAND WASTE MANAGEMENT CENTER


DRAWING NAME:

LEACHETE TANK

DRAWING NO:

DATE :	APRIL 2017
SCALE:	1:50
PROJECT NO :	00088179

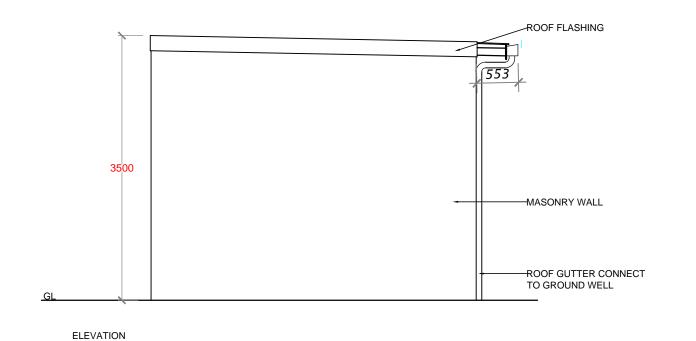

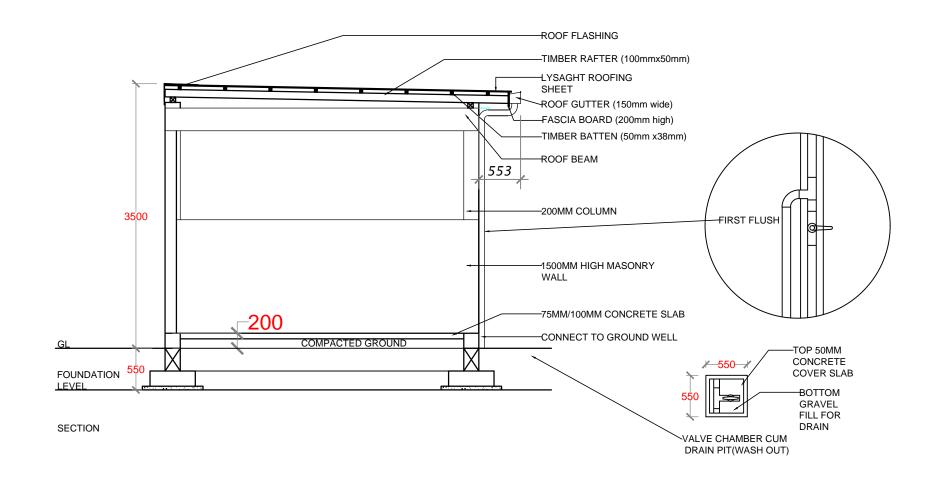



G.SARAVANAN CONSULTANT-CIVIL ENGINEER

CHECKED BY:

FATHIMATH SHAFA-ATH ENGINEER- MEE

APPROVED BY:

AISHATH AZFA

PROJECT MANAGER-LECRED-UNDP

IMPLEMENTING AGENCY:



United Nations Development Programme

IMPLEMENTING PARTNER:



Ministry of Environment and Energy

PROGRAMME:



Climate Resilient LECRED A Programme funded to the Covernment of Section Section of Section 1 and Advanced in the US in Section 1 and Se Low Emission Climate Resilient Develop

PROJECT NAME:

CONSTRUCTION & UPGRADE OF IWMC FOR 10 ISLANDS IN LAAMU ATOLL

ISLAND NAME:

LAAMU.

LOCATION:


ISLAND WASTE MANAGEMENT CENTER

DRAWING NAME:


ELEVATION & SECTION


DRAWING NO:


DATE :	APRIL 2017
SCALE :	1:50
PROJECT NO :	00088179

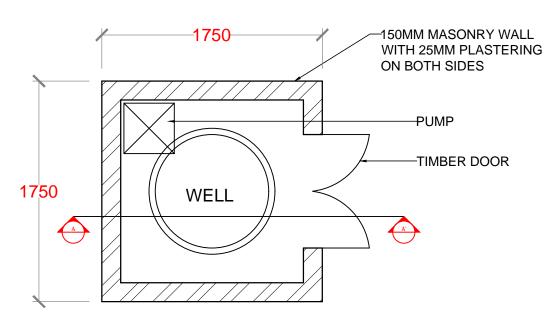


FRONT ELEVATION PUMP ROOM HUT PLAN

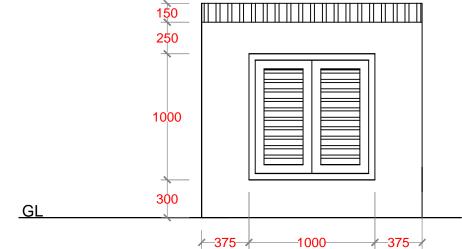

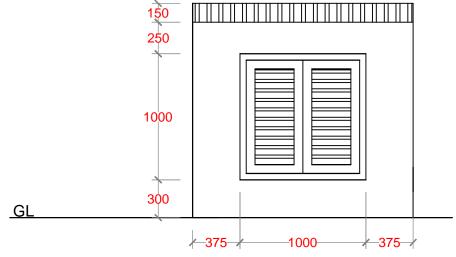

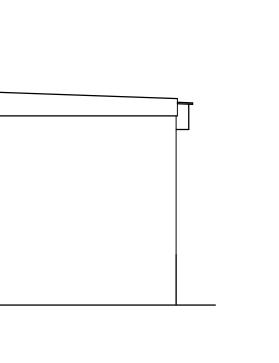


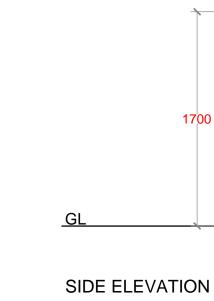


PREPARED BY: G.SARAVANAN CONSULTANT-CIVIL ENGINEER CHECKED BY: FATHIMATH SHAFA-ATH ENGINEER- MEE APPROVED BY: AISHATH AZFA PROJECT MANAGER-LECRED-UNDP IMPLEMENTING AGENCY: **United Nations** Development Programme IMPLEMENTING PARTNER: Ministry of Environment and Energy PROGRAMME: Low Emission Climate Resilient Develop PROJECT NAME: CONSTRUCTION & UPGRADE OF IWMC FOR 10 ISLANDS IN LAAMU ATOLL ISLAND NAME: LAAMU. LOCATION: ISLAND WASTE MANAGEMENT CENTER DRAWING NAME: PUMP ROOM HUT DETAILS DRAWING NO: 00088179/2017/IWMC/SD/007 DATE : APRIL 2017 SCALE: 1:30 PROJECT NO:


DATE


REVISION

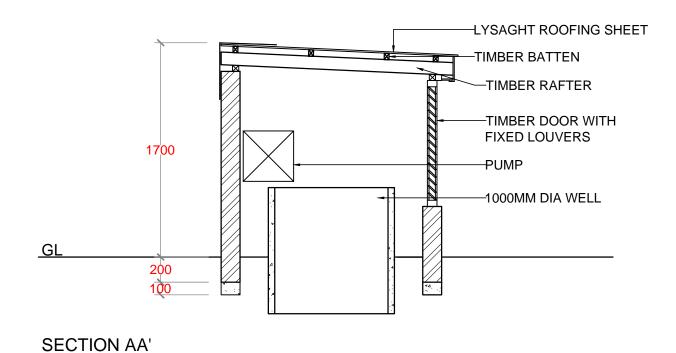

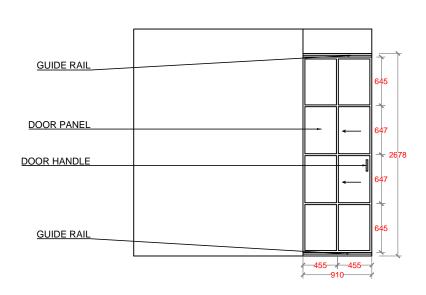

HAZARDOUS ROOM - METAL SLIDING DOOR

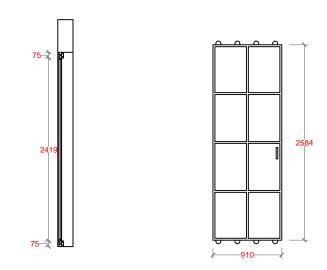

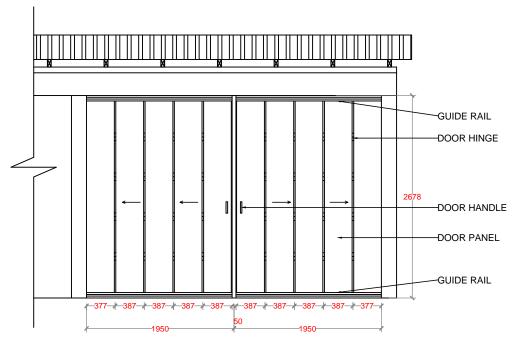

EQUIPMENT ROOM - METAL SLIDING DOOR



G.SARAVANAN CONSULTANT-CIVIL ENGINEER

CHECKED BY:

FATHIMATH SHAFA-ATH ENGINEER- MEE

APPROVED BY:

AISHATH AZFA PROJECT MANAGER-LECRED-UNDP

IMPLEMENTING AGENCY:



United Nations Development Programme



Environi Energy **Environment and**

PROGRAMME:



LECRED 4-Programme Apulated to the Consensation of Section 1 (2011) Apulation (2011) A Low Emission Climate Resilient Developm

PROJECT NAME:

CONSTRUCTION & UPGRADE OF IWMC FOR 10 ISLANDS IN LAAMU ATOLL

ISLAND NAME:

LAAMU.

LOCATION:


ISLAND WASTE MANAGEMENT CENTER


DRAWING NAME:

SLIDING DOOR DETAILS

DRAWING NO:


DATE :	APRIL 2017
SCALE :	1:50
PROJECT NO :	00088179

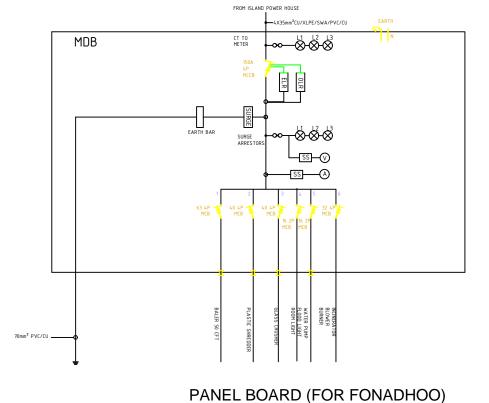

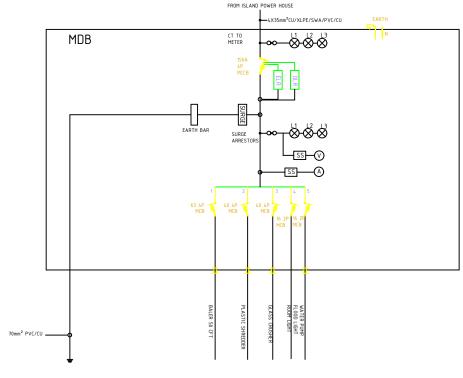

PANEL BOARD (FOR 9 ISLANDS)

TANLE BOARD (FOR FORADITOO)

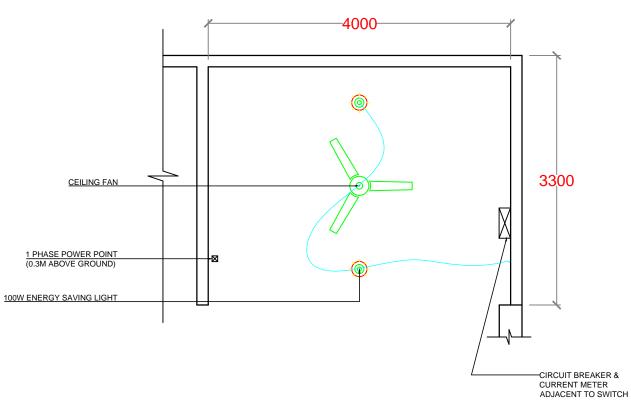

NO.	REVISION	DATE

PREPARED BY:

G.SARAVANAN CONSULTANT-CIVIL ENGINEER

CHECKED BY:

FATHIMATH SHAFA-ATH ENGINEER- MEE

APPROVED BY:

AISHATH AZFA

PROJECT MANAGER-LECRED-UNDP

IMPLEMENTING AGENCY:



United Nations Development Programme



Ministry of Environment and Energy

PROGRAMME:



Development

Anguer and all the format and the first and t

Low Emission Climate Resilient Developme

PROJECT NAME:

CONSTRUCTION &
UPGRADE OF IWMC FOR 10
ISLANDS IN LAAMU ATOLL

ISLAND NAME:

LAAMU.

LOCATION:


ISLAND WASTE MANAGEMENT CENTER

DRAWING NAME:


ELECTRICAL LAYOUT

DRAWING NO:


DATE :	APRIL 2017
SCALE:	1:50
PROJECT NO :	00088179

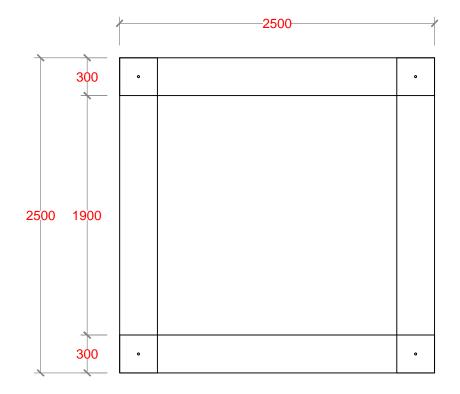


PLAN

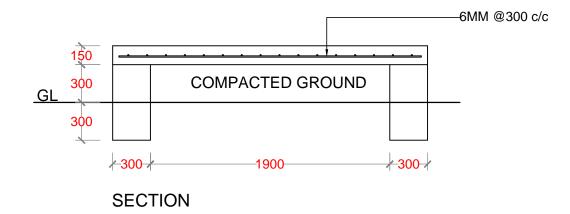

RAINWATER TANK FOR 2500 Ltr

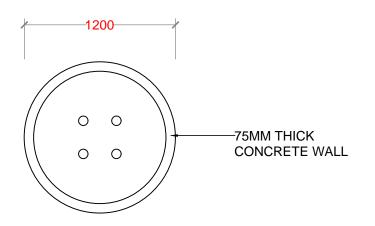


PLAN

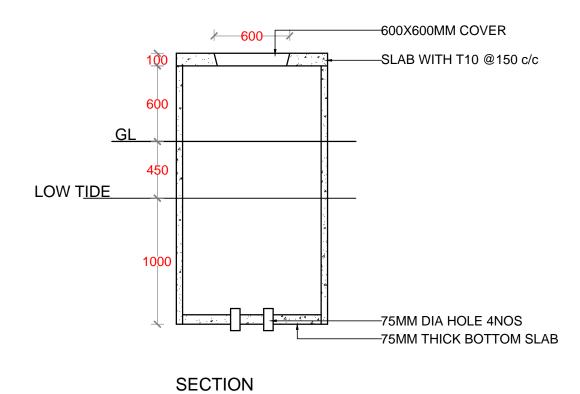


GROUND WATER WELL

NO.	REVISIO	N	DATE
PRE	PARED BY:		
_	SARAVANA NSULTANT-CIV		NEER
CHE	CKED BY:		
	THIMATH S	SHAFA	-ATH
APP	ROVED BY:		
	SHATH AZF OJECT MANAG		RED-UNDP
IMPL	EMENTING AG	SENCY:	
U	N Deve	ed Nati Iopme	nt
D		ramme	:
Ministry of Environment and Energy			
PRO	GRAMME:		
Lecked Low Emission Climate Resilient Development Lecked Low Emission Climate Resilient Development			
CC	DIECT NAME: DNSTRUCTI PGRADE OF	-	FOR 10
ISL	ANDS IN L	AAMU	ATOLL
ISLA	ND NAME:		
LAAMU.			
LOCATION:			
ISLAND WASTE MANAGEMENT CENTER			
DRAWING NAME:			
GROUND WATER WELL & RAINWATER TANK DETAILS			
DRAWING NO:			
00088179/2017/IWMC/SD/010			
DAT	E :	APRIL 2	2017

SCALE:

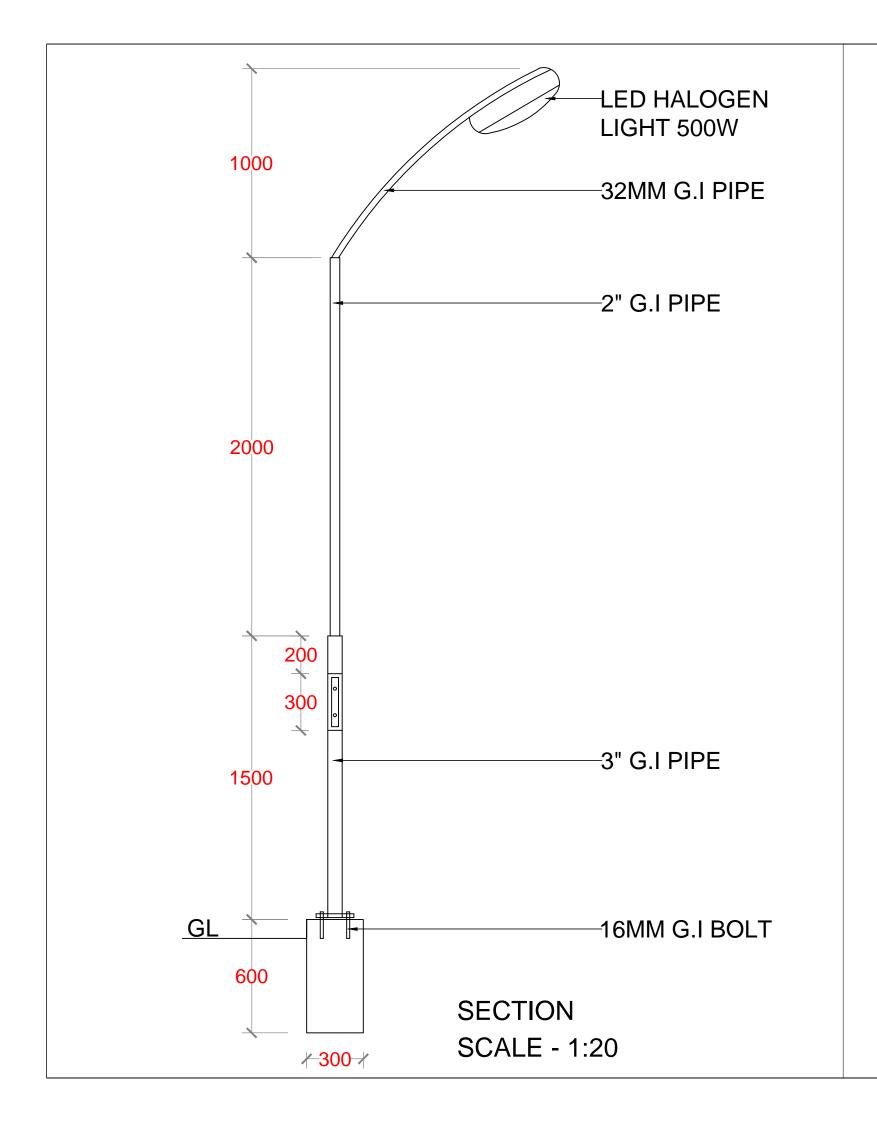

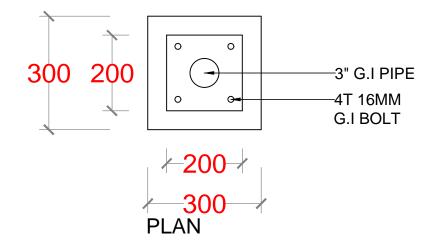



G.SARAVANAN CONSULTANT-CIVIL ENGINEER

CHECKED BY:

FATHIMATH SHAFA-ATH ENGINEER- MEE

APPROVED BY:

AISHATH AZFA

PROJECT MANAGER-LECRED-UNDP

IMPLEMENTING AGENCY:



United Nations Development Programme



Ministry of **Environment and** Energy

PROGRAMME:



Low Emission Climate Resilient Develop

PROJECT NAME:

CONSTRUCTION & UPGRADE OF IWMC FOR 10 ISLANDS IN LAAMU ATOLL

ISLAND NAME:

LAAMU.

LOCATION:

ISLAND WASTE MANAGEMENT CENTER

DRAWING NAME:

FLOOD LIGHT DETAILS

DRAWING NO:

00088179/2017/IWMC/SD/011

DATE :	APRIL 2017
SCALE :	AS SHOWN

PROJECT NO:

