


TOILET DRAINAGE LAYOUT

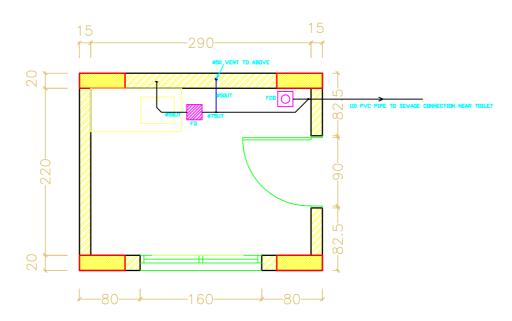

KIOSKE DRAINAGE LAYOUT

Key Plan

 
DRAINAGE LAYOUT
TOILET & KIOSKE DETAILS

LEGEND

UT: UNDER TILE

FD: FLOOR DRAIN

FCO: FLOOR CLEANOUT



Revisions

THIS DRAWING IS A COPYRIGHT. DO NOT SCALE FROM THE DRAWING. THE CONTRACTOR AND HIS SUB-CONTRACTORS ARE TO VERIFY ALL DIMENSIONS ON SITE BEFORE MAKING SHOP DRAWINGS OR COMMENCING MANUFACTURE.



United Nation Development Programme UNDP Lebanon Social and Local Development Programme P.O.Box: 11-3216 Beirut, Lebanon Tel: 961 1 962491



Lebanese Host Communities Support Programme Support to Integrated Service Provision at the Local Level

PROJECT: REHABILITATION OF A PUBLIC PARK - BOURJ HAMMOUD

Sheet Information PROJECT NBR. TENDER PROJECT PHASE DISCIPLINE MECHANICAL SECTOR BUILDING DESIGNED DRAWN CHECKED APPROVED DATE 23 NOV. 2015 SCALE NOT TO SCALE SHEET SIZE


Sheet Title

DRAINAGE LAYOUT TOILET & KIOSKE DETAILS

Sheet nbr.

DR-01

Phase Discipline Floor Area Drawing Number Revision

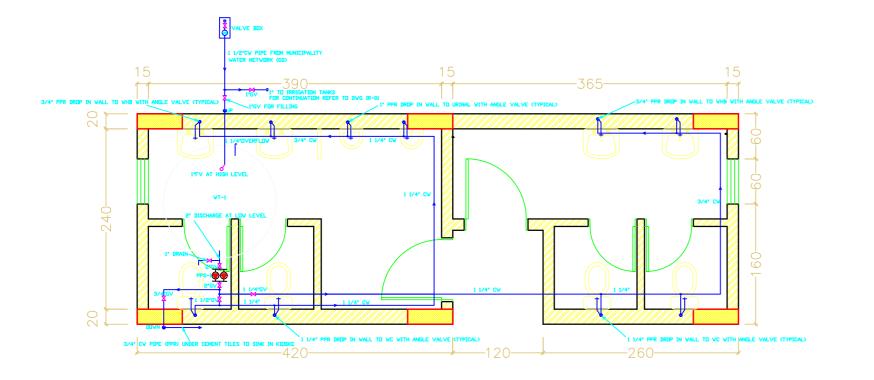

220 220 100 80 80.5-

TOILET WATER SUPPLY LAYOUT

KIOSKE WATER SUPPLY LAYOUT

Key Plan

WATER SUPPLY LAYOUT TOILET & KIOSKE DETAILS

LEGEND

CW: COLD WATER

GS: GALVANIZED STEEL

GV: GATE VALVE

FV: FLOAT VALVE

WM: WATER METER

NOTES

1- EXPOSED CW PIPES ARE GS

2- 3/4" denoted = 20mm GS = 25MM PPR



Revisions

THIS DRAWING IS A COPYRIGHT. DO NOT SCALE FROM THE DRAWING.
THE CONTRACTOR AND HIS SUB-CONTRACTORS ARE TO VERIFY ALL
DIMENSIONS ON SITE BEFORE MAKING SHOP DRAWINGS OR
COMMENCING MANUFACTURE.



United Nation Development Programme UNDP Lebanon

Social and Local Development Programme P.O.Box: 11-3216 Beirut, Lebanon Tel: 961 1 962491



Lebanese Host Communities Support Programme Support to Integrated Service Provision at the Local Level

PROJECT:

REHABILITATION OF A PUBLIC PARK - BOURJ HAMMOUD

	Sheet Information
PROJECT NBR.	-
PROJECT PHASE	TENDER
DISCIPLINE	MECHANICAL
SECTOR	-
BUILDING	-
DESIGNED	-
DRAWN	
CHECKED	
APPROVED	
DATE	23 NOV. 2015
SCALE	NOT TO SCALE
SHEET SIZE	

Sheet Title

WATER SUPPLY LAYOUT TOILET & KIOSKE DETAILS

Sheet nbr.

WS-01

Discipline Floor Area Drawing Number Revis


SCHEDULE OF PACKAGED BOOSTER PUMPS (European made) FLOW RATE HEAD TAG NO. SYSTEM SERVED LOCATION FLUID REMARKS TYPE QUANTITY (M3/HR)PPS-1 DOMESTIC WATER SYSTEM TOILETS ROOF VERTICAL MULTISTAGE | DOMESTIC WATER DUTY & 1 STAND-BY 12.5 1 SET PPS-2 | IRRIGATION WATER SYSTEM REFER TO DWG IR-01 VERTICAL MULTISTAGE | IRRIGATION WATER 1 DUTY & 1 STAND-BY 4.75 1 SET

NOTE:

FINAL HEAD TO BE VERIFIED BY CONTRACTOR UPON SELECTION OF EQUIPMENT.

SCHEDULE OF WATER TANKS (NTG)							
TAG NO.	SYSTEM SERVED	LOCATION	MATERIAL	QUANTITY	CAPACITY		
WT-1	DOMESTIC WATER SYSTEM	TOILETS ROOF	POLYETHYLENE TRIPLE LAYER	1	2000L		
WT-2	IRRIGATION WATER SYSTEM	REFER TO DWG IR-01	POLYETHYLENE TRIPLE LAYER	2	2000L		

Key Plan MECHANICAL EQUIPMENT SCHEDULE REV BY APP DESCRIPTION DATE Revisions THIS DRAWING IS A COPYRIGHT. DO NOT SCALE FROM THE DRAWING. THE CONTRACTOR AND HIS SUB-CONTRACTORS ARE TO VERIFY ALL DIMENSIONS ON SITE BEFORE MAKING SHOP DRAWINGS OR COMMENCING MANUFACTURE. United Nation Development Programme **UNDP** Lebanon Social and Local Development Programme P.O.Box: 11-3216 Beirut, Lebanon Tel: 961 1 962491 PROGRAMME: Lebanese Host Communities Support Programme Support to Integrated Service Provision at the Local Level PROJECT: REHABILITATION OF A PUBLIC PARK - BOURJ HAMMOUD **Sheet Information** PROJECT NBR. TENDER PROJECT PHASE MECHANICAL DISCIPLINE SECTOR BUILDING DESIGNED DRAWN CHECKED APPROVED DATE 23 NOV. 2015 SCALE NOT TO SCALE SHEET SIZE **Sheet Title EQUIPMENT SCHEDULE** Sheet nbr. M-01

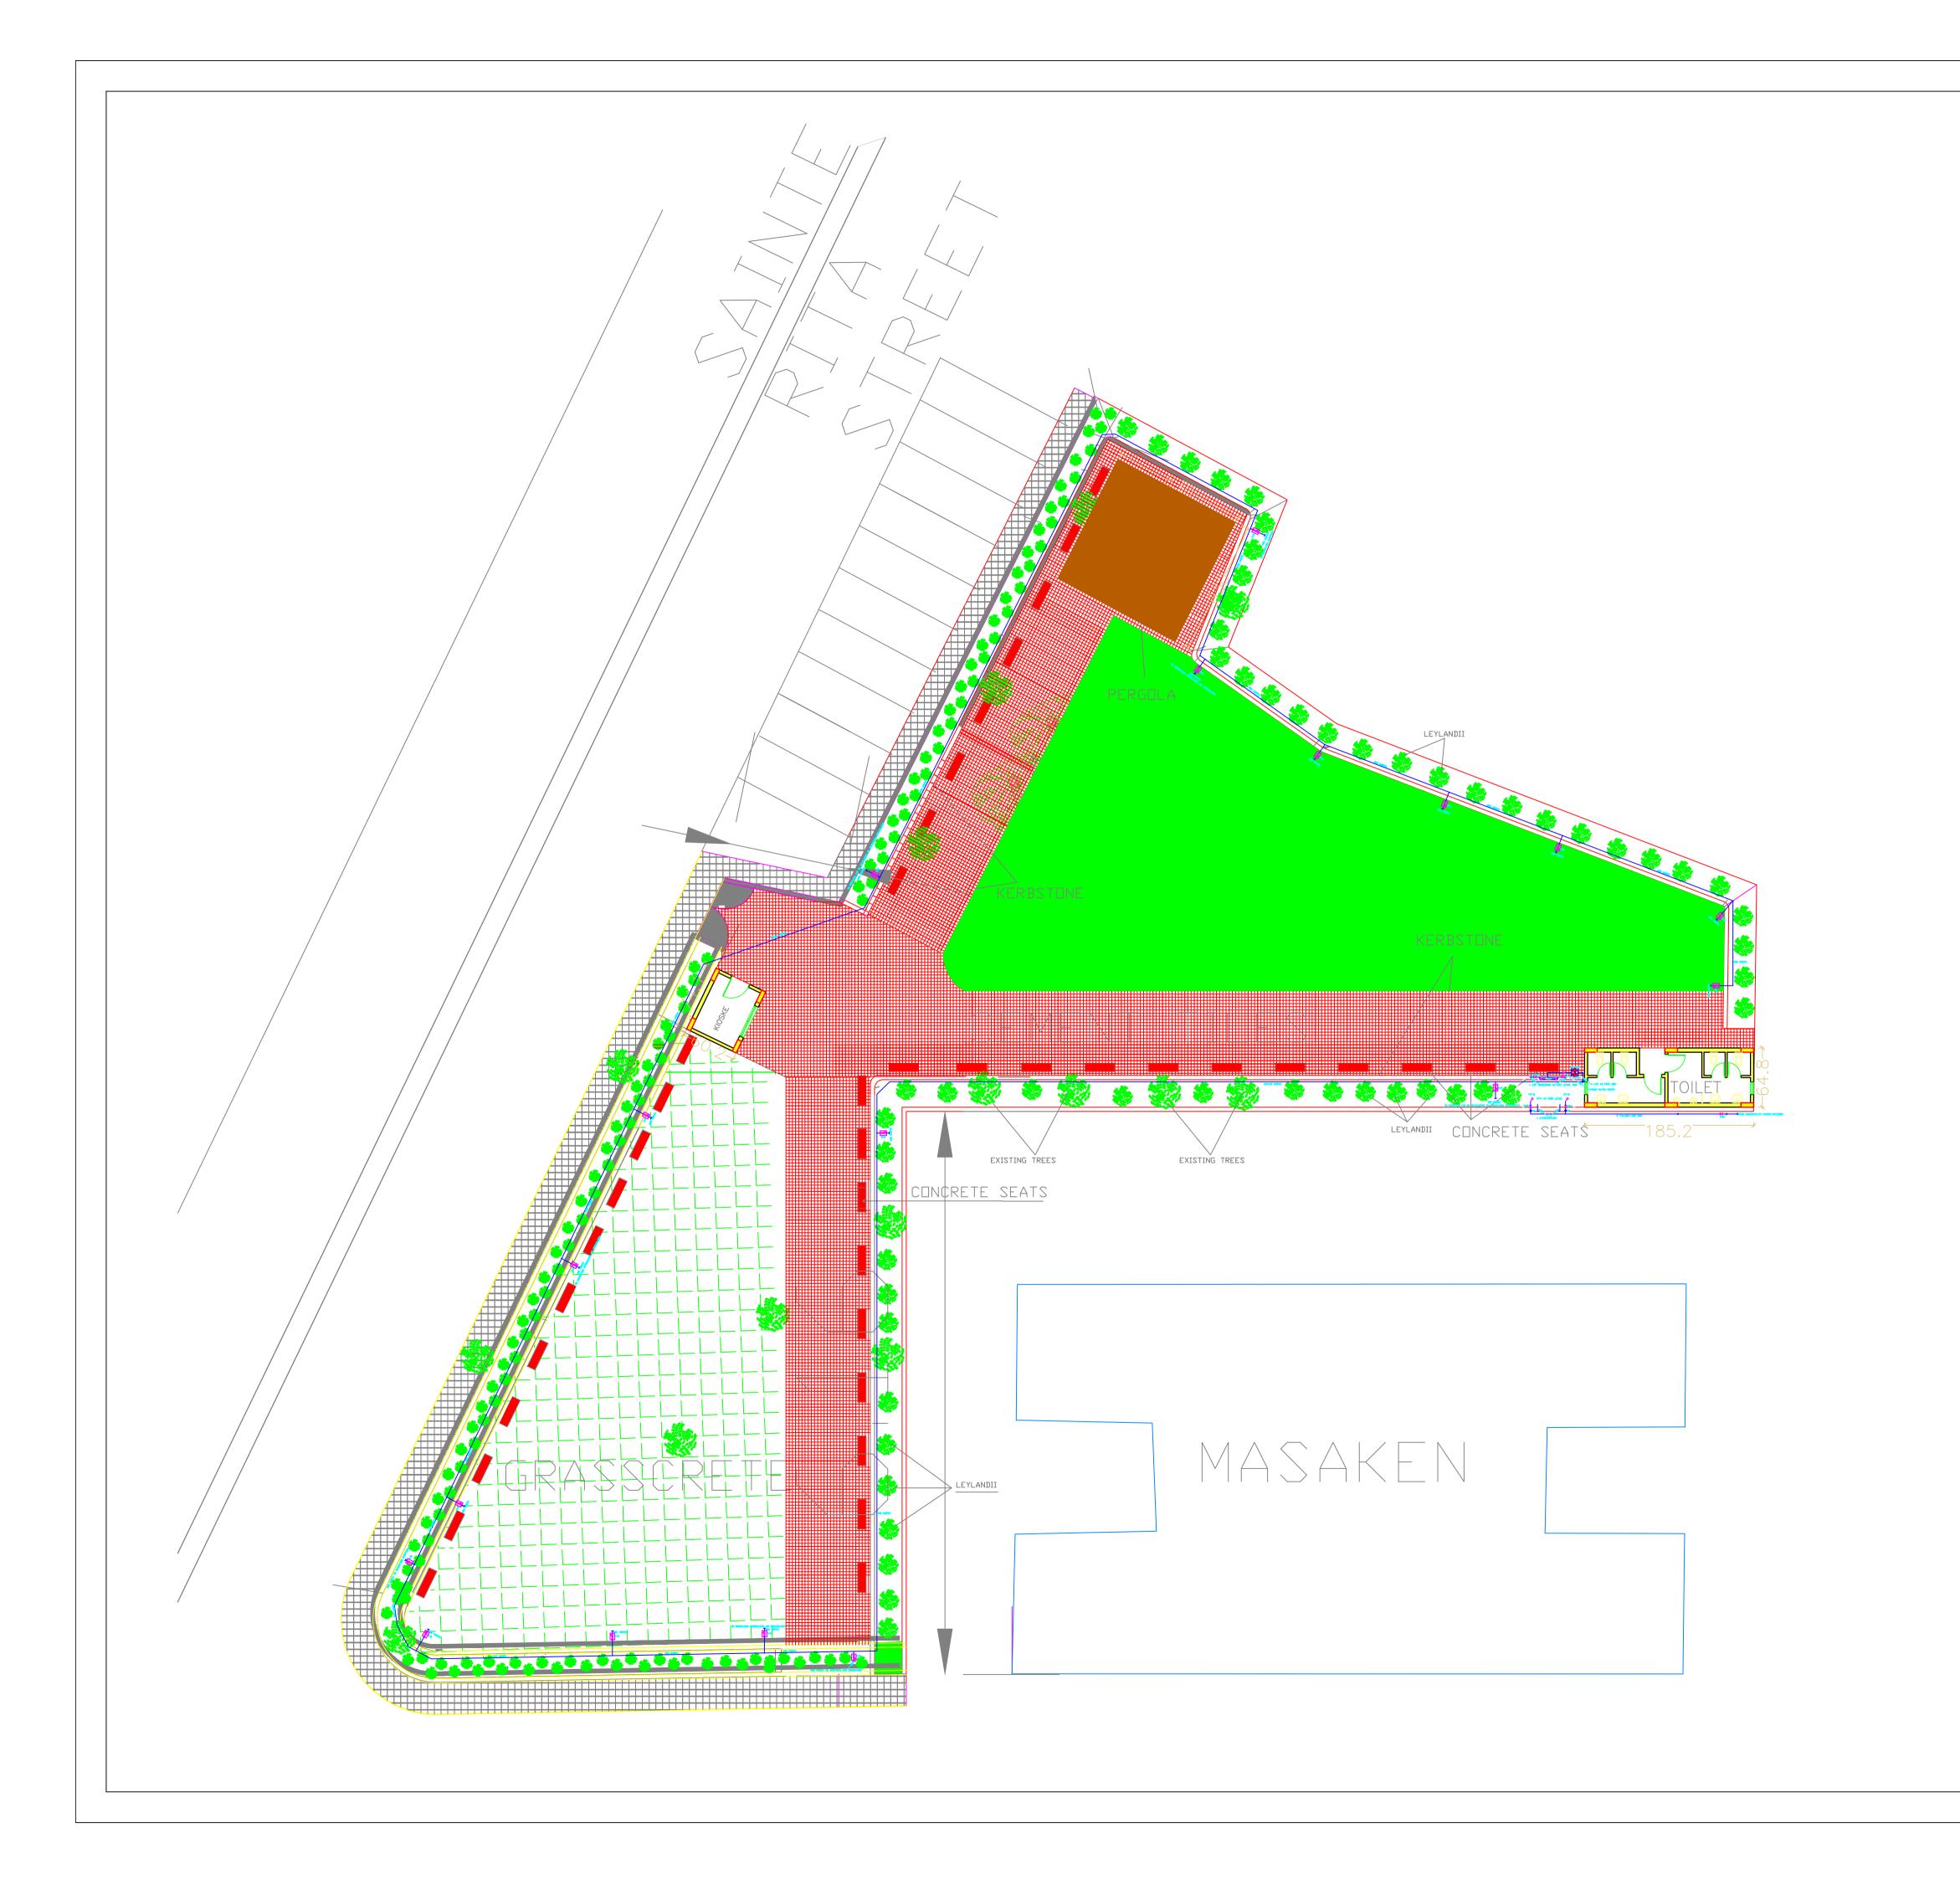

Key Plan

IRRIGATION LAYOUT

LEGEND

 
IW: IRRIGATION WATER IVB: IRRIGATION VALVE BOX

GV: GATE VALVE FV: FLOAT VALVE GS: GALVANIZED STEEL

UT: UNDER TILE

UNDER GROUND

HDPE: HIGH DENSITY POLYETHYLENE



Revisions

THIS DRAWING IS A COPYRIGHT. DO NOT SCALE FROM THE DRAWING THE CONTRACTOR AND HIS SUB-CONTRACTORS ARE TO VERIFY ALL DIMENSIONS ON SITE BEFORE MAKING SHOP DRAWINGS OR COMMENCING MANUFACTURE.



United Nation Development Programme **UNDP** Lebanon Social and Local Development Programme

P.O.Box: 11-3216 Beirut, Lebanon Tel: 961 1 962491



Lebanese Host Communities Support Programme
Support to Integrated Service
Provision at the Local Level

PROJECT: REHABILITATION OF A PUBLIC PARK - BOURJ HAMMOUD

	Sheet Information
PROJECT NBR.	-
PROJECT PHASE	TENDER
DISCIPLINE	MECHANICAL
SECTOR	-
BUILDING	-
DESIGNED	-
DRAWN	
CHECKED	
APPROVED	
DATE	23 NOV. 2015
SCALE	-
SHEET SIZE	

Sheet Title

IRRIGATION LAYOUT

Sheet No.

IR-01

Phase Discipline Floor Area Drawing Number Revision

